
 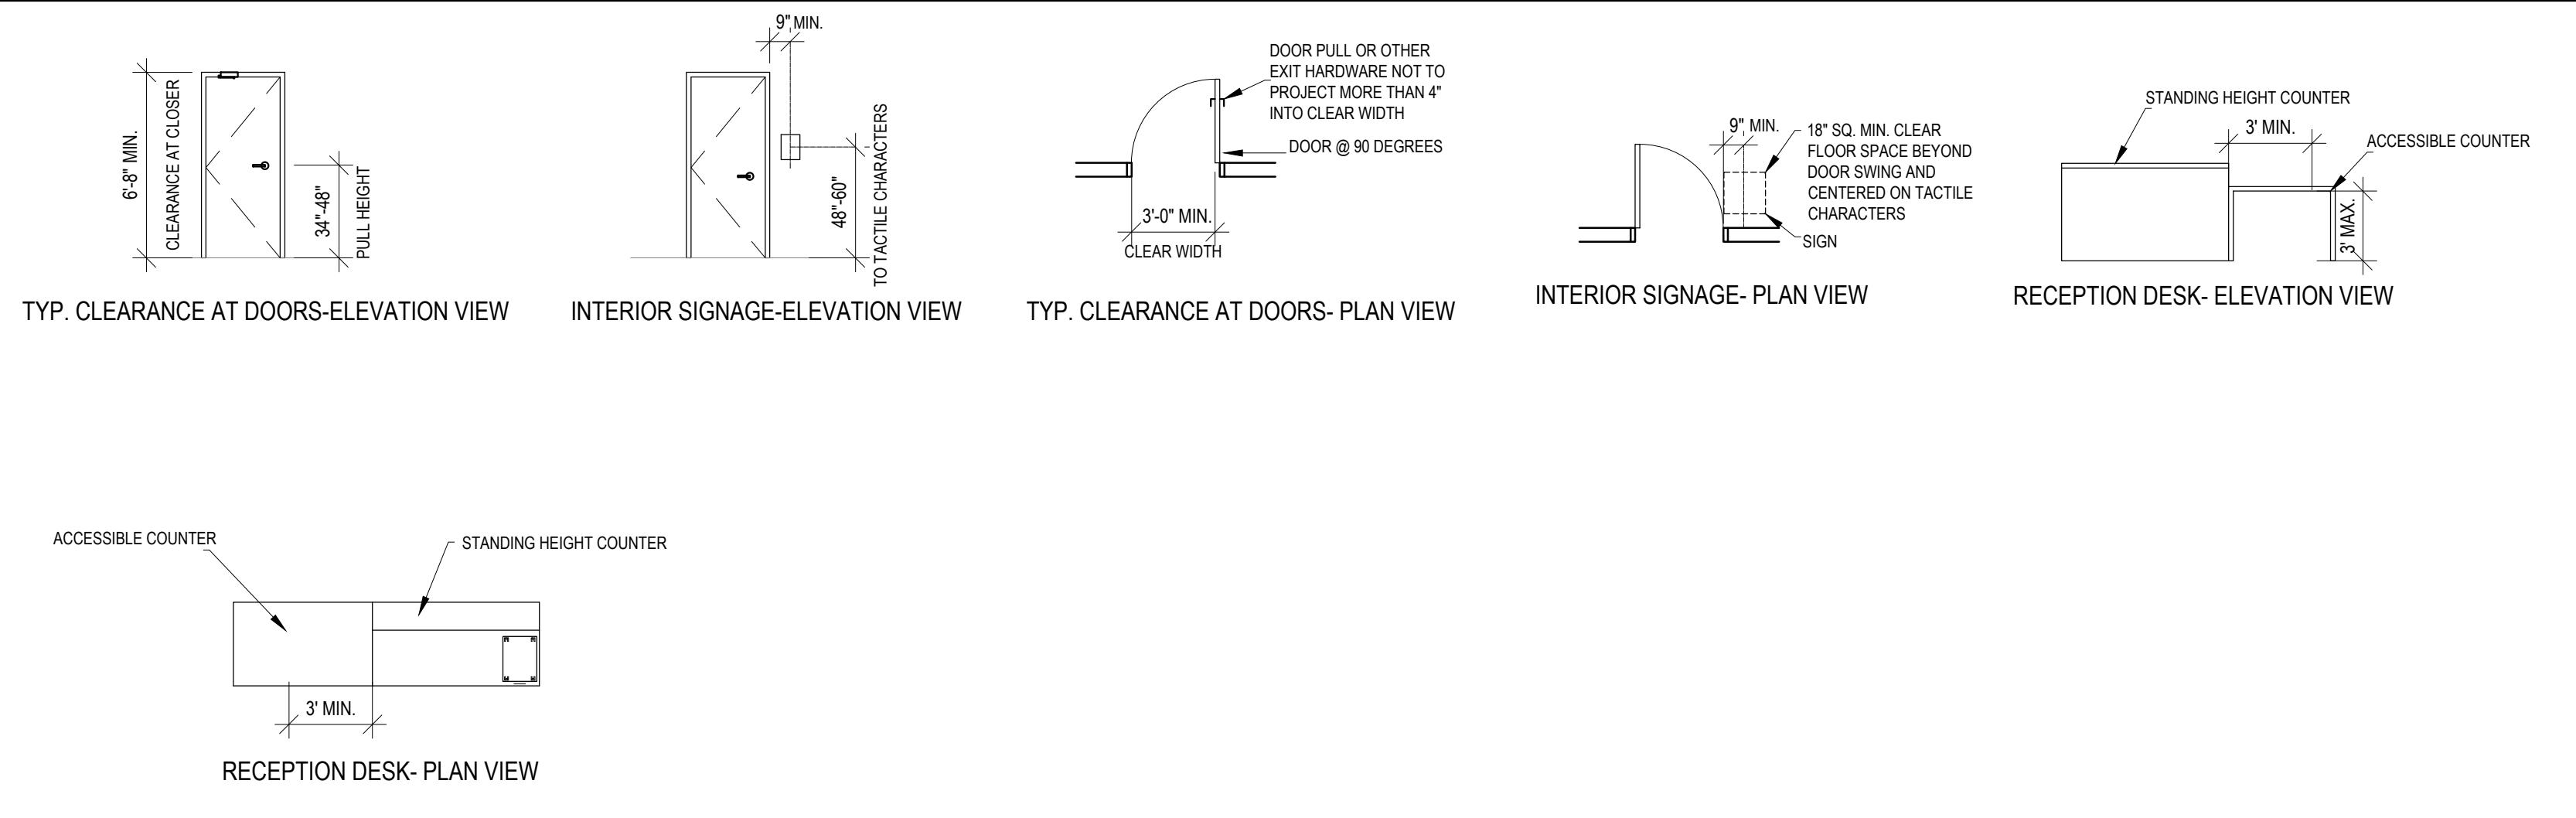

 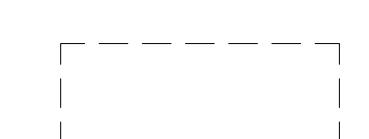



ADA STANDARD MOUNTING HEIGHTS

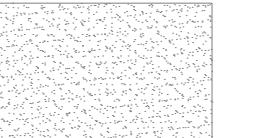

ABBREVIATIONS	DRAWING SYMBOLS	MATERIAL INDEX	BUILDING CODE SUMMARY
DWG-DRAWING AFF-ABOVE FINISHED FLOORING	 DRAWING NAME SCALE  N  OFFICE 314  DRAWING NUMBER PAGE NUMBER   DRAWING NUMBER PAGE NUMBER  DRAWING NUMBER PAGE NUMBER  SECTION PAGE NUMBER  FURNITURE REFERENCE SYMBOL	 BRICK  GYPSUM BOARD  CONCRETE	ADOPTED JURISDICTIONAL CODES INTERNATIONAL BUILDING CODE 2012 THE CODES GUIDEBOOK FOR INTERIORS 2008 NATIONAL COUNCIL FOR INTERIOR DESIGN QUALIFICATION 2016.8.1 2013 OCCUPANCY CLASSIFICATION BUSINESS (B) OCCUPANCY OCCUPANCY LOAD 100 (9.3 M ²) GROSS CONSTRUCTION TYPE (STEEL FRAME) SQUARE FOOTAGE REG. EXEC. DIR.- 400 SQ FT REG. BRD. SEC., REG. FIN. DIR., REG. HR DIR.- 225 SQ FT OFFICERS (X3)- 100 SQ FT STAFF (X5)- 60 SQ FT RECEPTIONIST- 60 SQ FT BOARD ROOM- 425 SQ FT SMALL CONFERENCE ROOM- 250 SQ FT TEAMING AREA- 200 SQ FT BREAK ROOM- 200 SQ FT FILE/WORK AREA- 300 SQ FT COAT AREA- 50 SQ FT LOBBY AREA- 200 SQ FT
GENERAL NOTES			
			COVER PAGE

DRAWING INDEX:	
A3.3	FLOOR PLAN
A3.9	FLOOR PATTERN PLAN
A4.0	FF&E PLAN
A4.3	RECEPTIONIST SECTIONS
A4.8	WALL SECTION
A5.0	ELEVATIONS
A5.5	RECEPTIONIST STATION ELEVATIONS
A6.3	REFLECTED CEILING PLAN
A10.3	OFFICER WORKSTATION LARGE SCALE PLAN
E2.3	POWER AND COMMUNICATION PLAN



COVER PAGE

GIGIS PLAYHOUSE

DRAWN BY:
GRACE DIETZ
COURSE: ADHM 253
DATE: FEBRUARY 22, 2017

A.COVER

NOTES:
-INTERIOR OFFICE WALLS:
5" STEEL FRAME
CONSTRUCTION

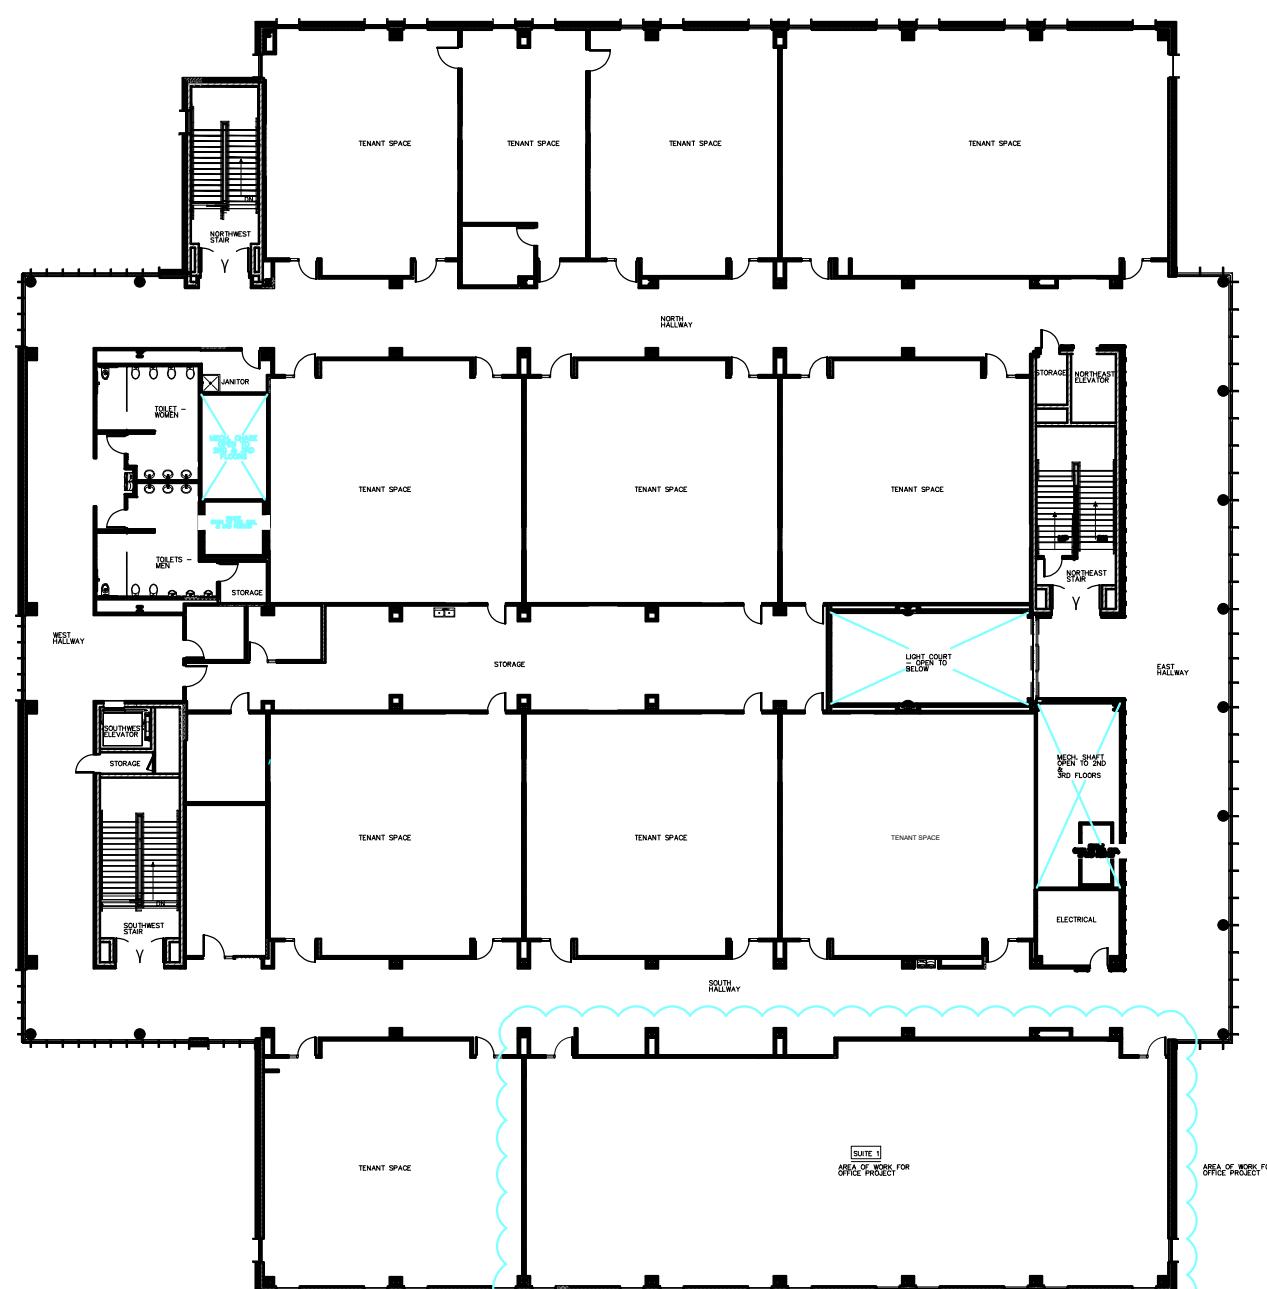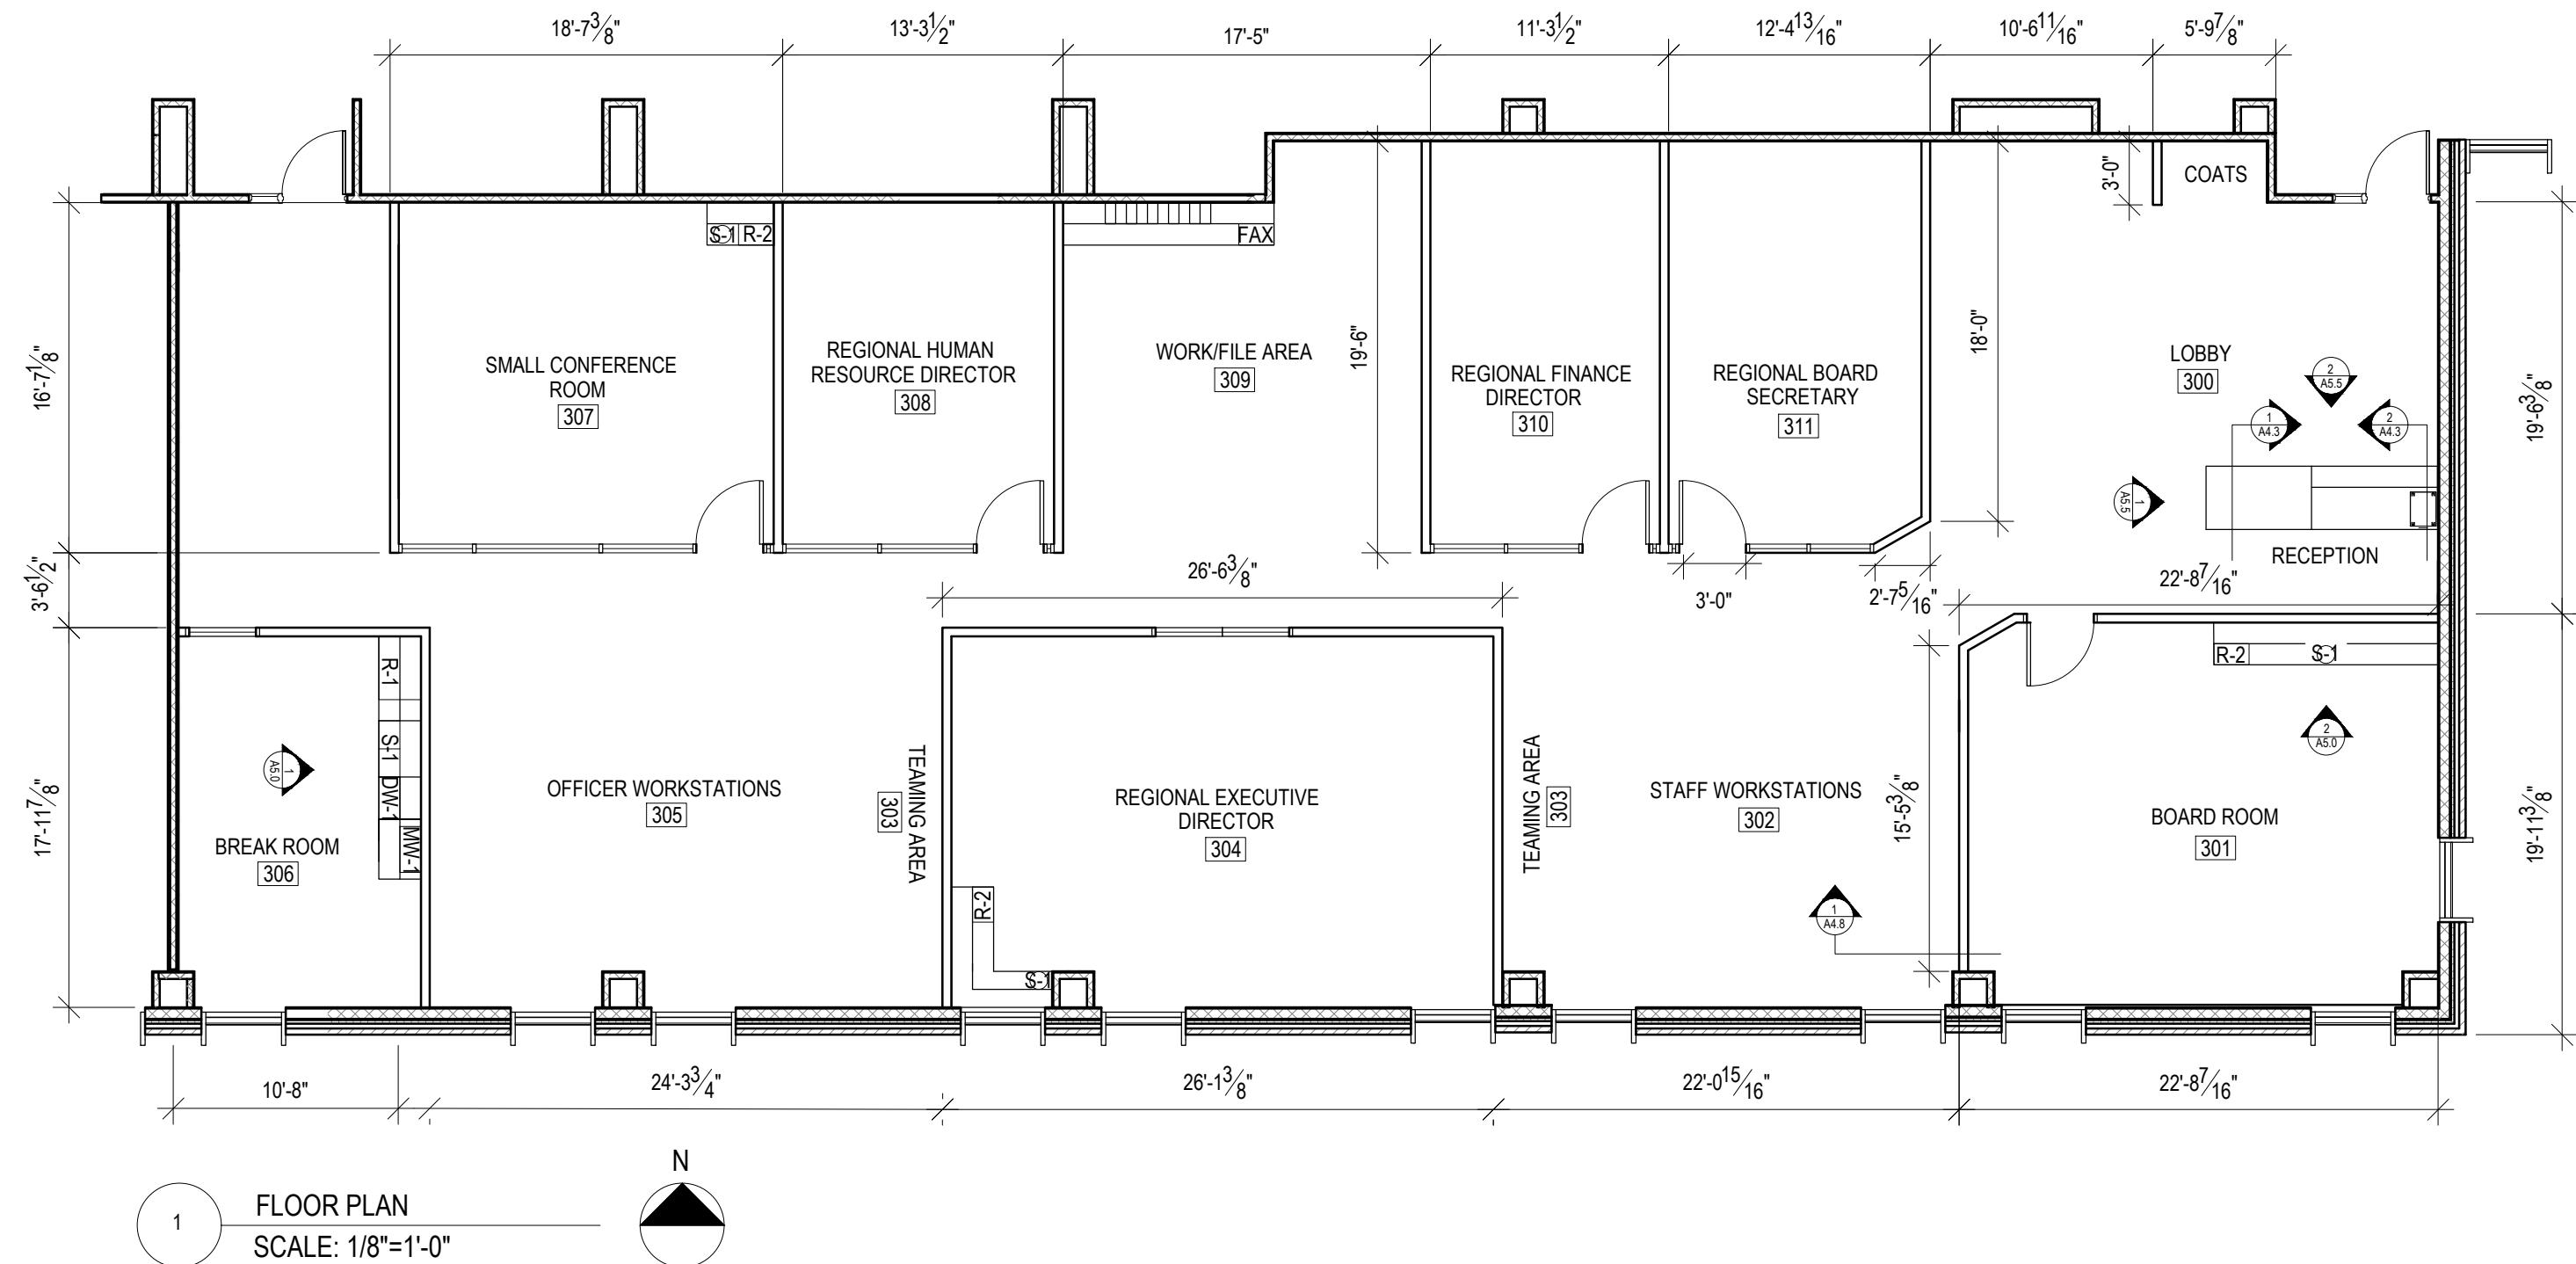


FLOOR PLAN


GIGIS
PLAYHOUSE

DRAWN BY:
GRACE DIETZ
COURSE: ADHM 253
DATE: FEBRUARY 22, 2017

A3.3

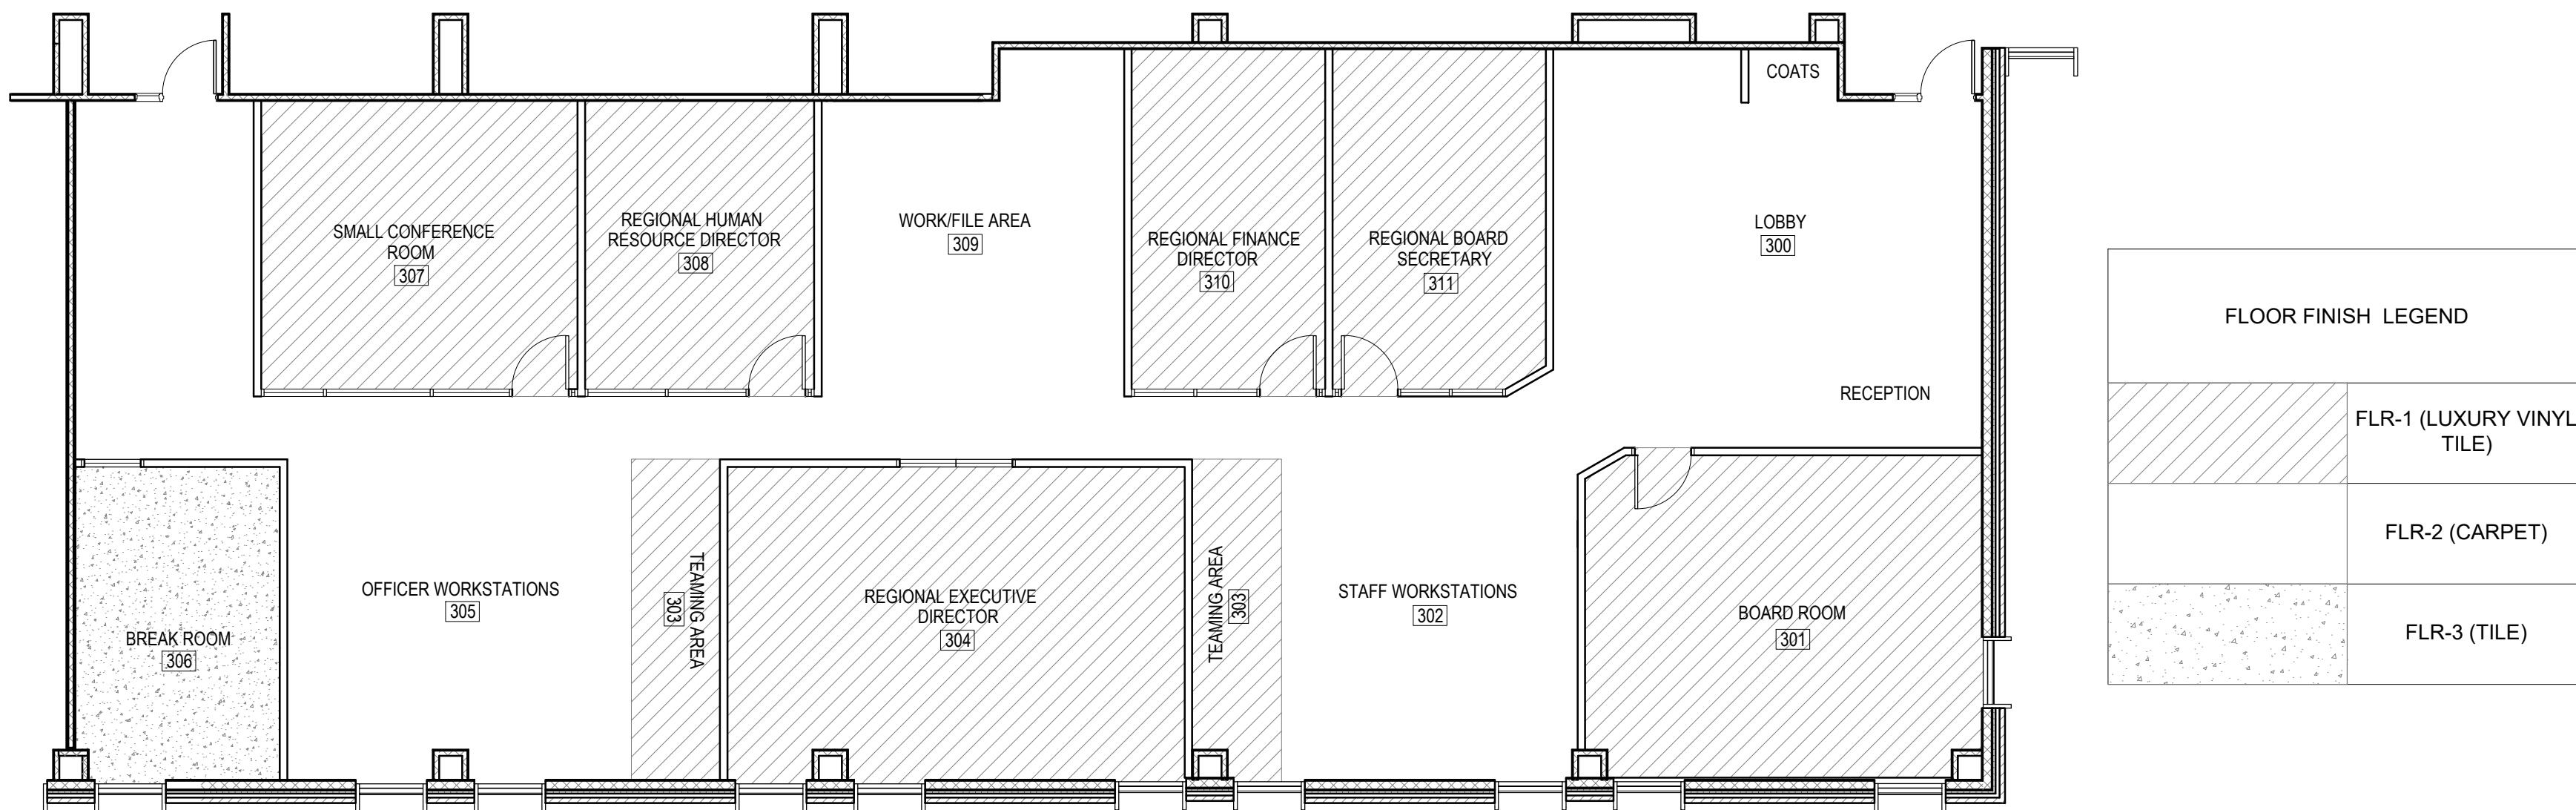

1 FLOOR FINISH PLAN
SCALE: 1/8"=1'-0"

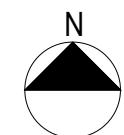


FLOOR FINISH PLAN

GIGIS
PLAYHOUSE

DRAWN BY:
GRACE DIETZ
COURSE: ADHM 253
DATE: FEBRUARY 22, 2017

A3.9

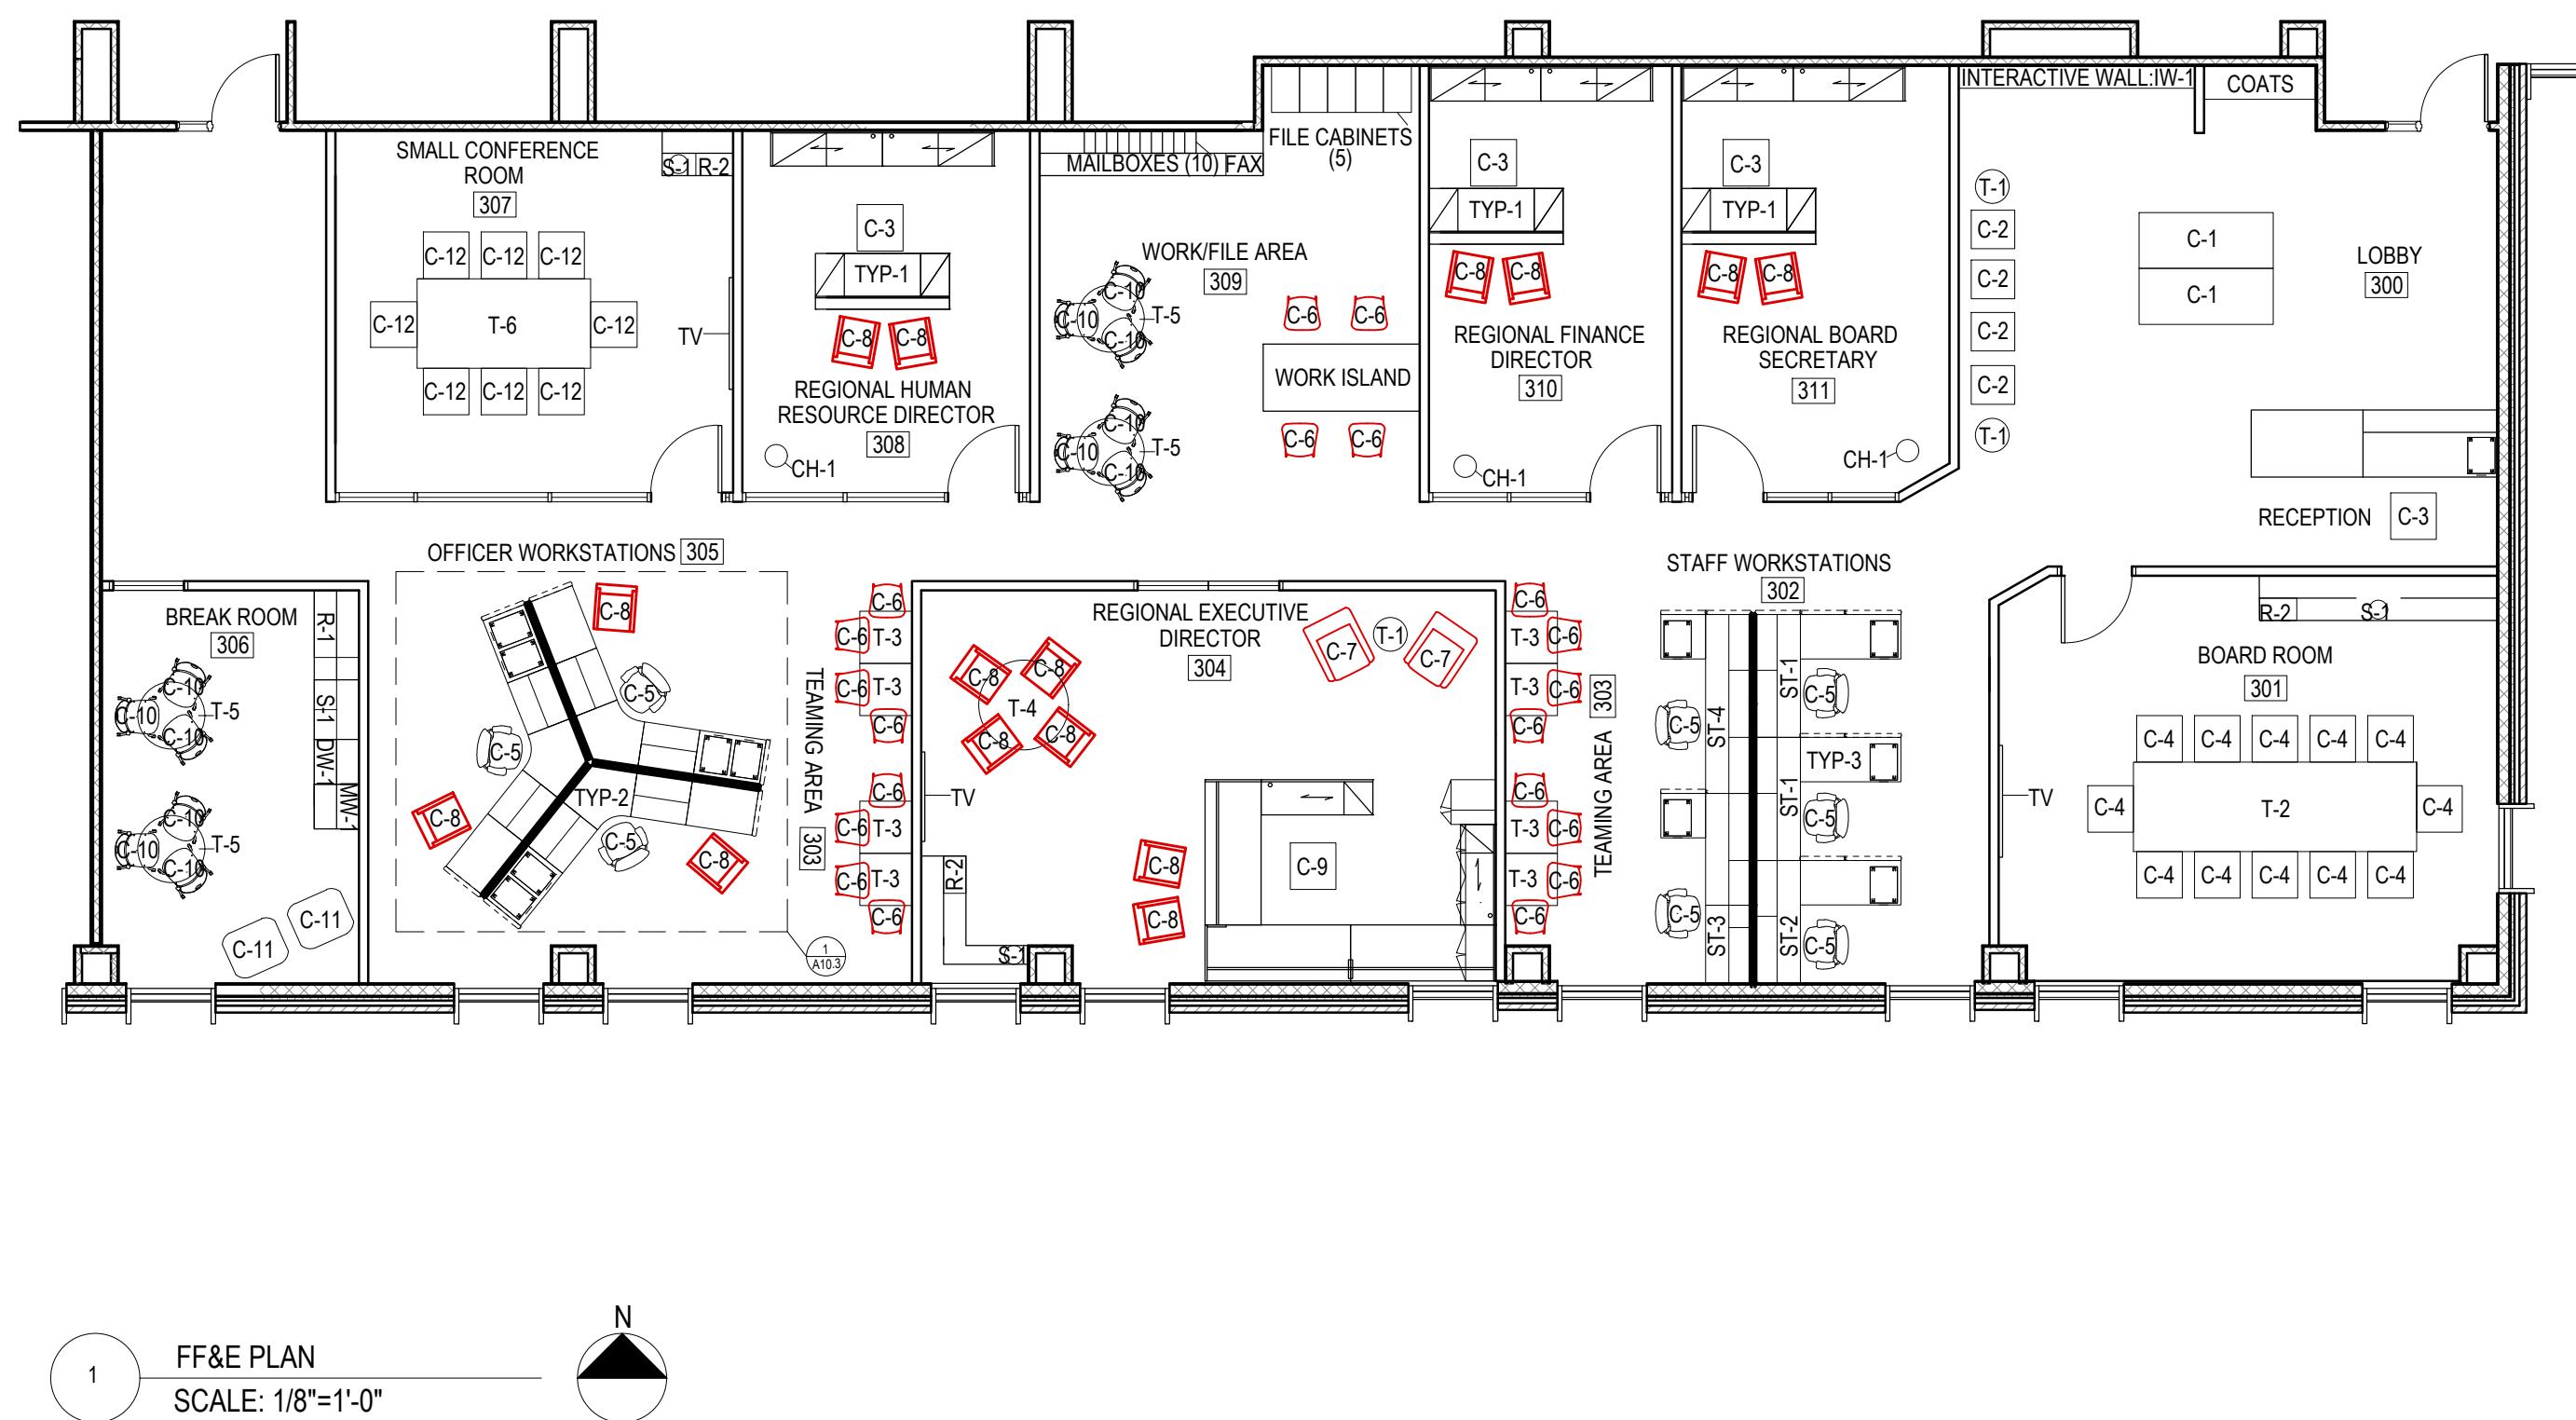

FF&E PLAN


GIGIS
PLAYHOUSE

DRAWN BY:
GRACE DIETZ
COURSE: ADHM 253
DATE: FEBRUARY 22, 2017

A4.0



1 RECEPTIONIST SECTION
SCALE: 1"=1'-0"

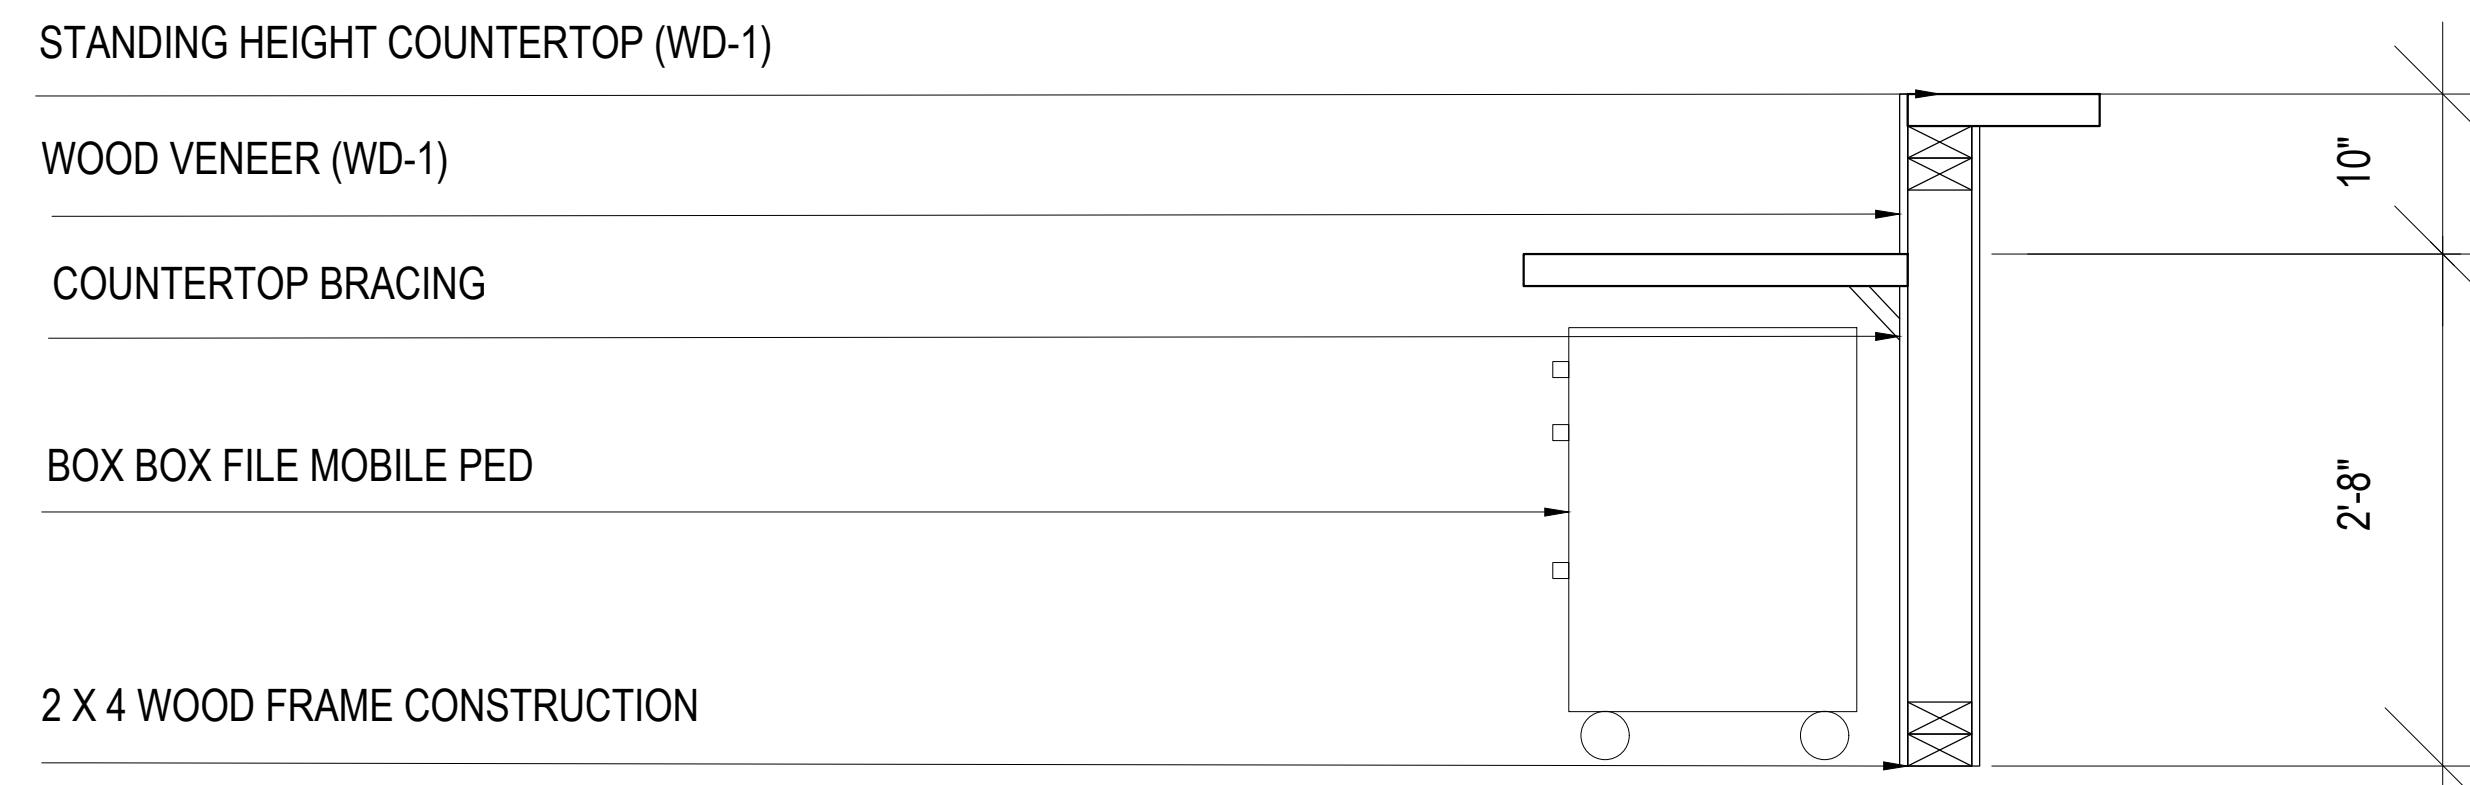

2 RECEPTIONIST SECTION
SCALE: 1"=1'-0"

RECEPTIONIST SECTIONS

GIGIS
PLAYHOUSE

DRAWN BY:
GRACE DIETZ
COURSE: ADHM 253
DATE: FEBRUARY 22, 2017

4" HOLLOW CORE CONCRETE (TOP AND BOTTOM)

24" X 24" ACOUSTICAL CEILING TILE: L TRACK

9'-6" SOFFIT (GYPSUM BOARD)


ACOUSTICAL SOUND INSULATION

5/8" GYPSUM BOARD

3 5/8" METAL STUD

STEEL TRACK (TOP AND BOTTOM, BOTH SIDES)
SOUND/FIRESTOP SEALANT (TOP AND BOTTOM, BOTH SIDES)

1" CONCRETE

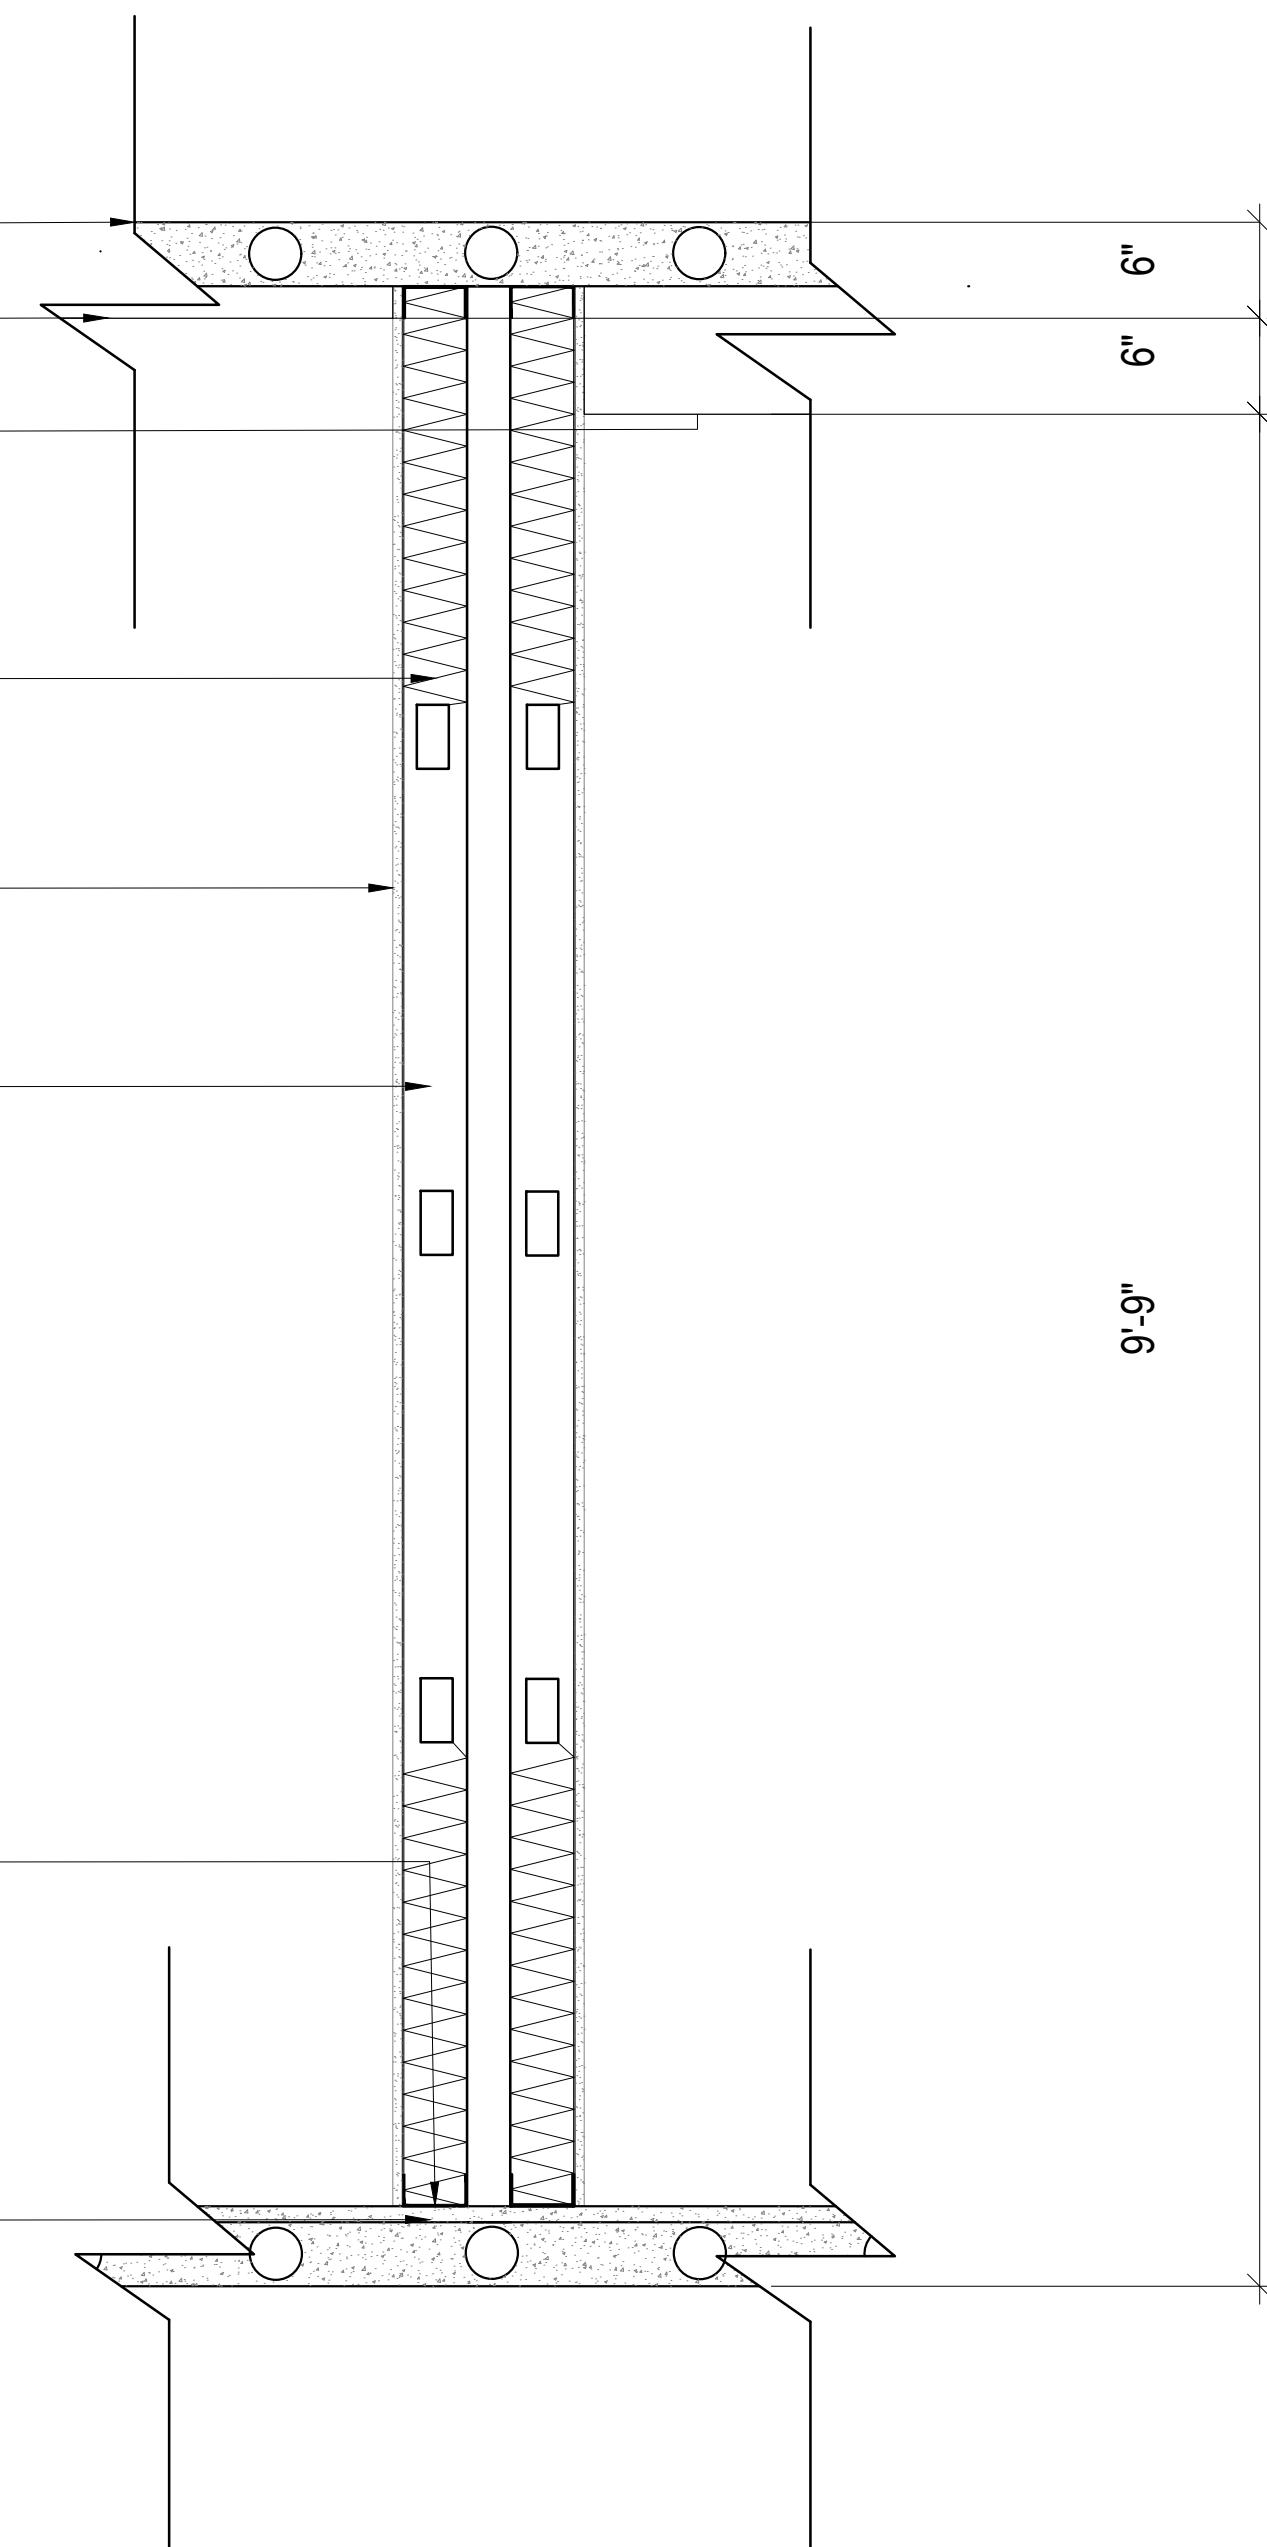


WALL SECTION

GIGIS
 PLAYHOUSE


 DRAWN BY:
 GRACE DIETZ
 COURSE: ADHM 253
 DATE: FEBRUARY 22, 2017

 1
 WALL SECTION
 SCALE: 1"=1'-0"

A4.8

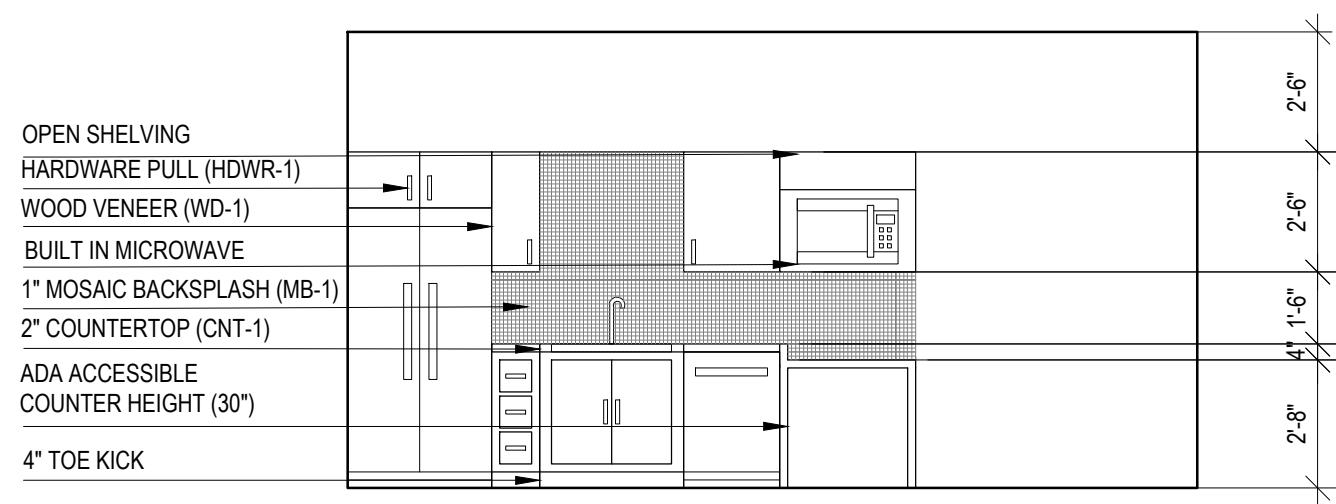

1 BREAK ROOM EAST WALL ELEVATION
SCALE: 1/4"=1'-0"

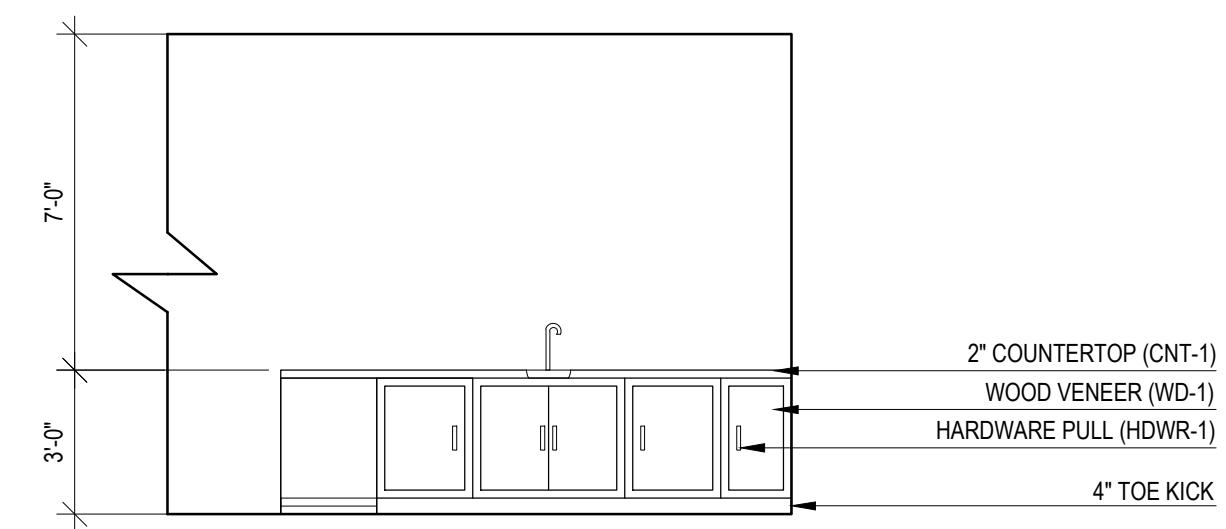


2 BOARD ROOM NORTH WALL ELEVATION
SCALE: 1/4"=1'-0"

INTERIOR ELEVATIONS


GIGIS
PLAYHOUSE

DRAWN BY:
GRACE DIETZ
COURSE: ADHM 253
DATE: FEBRUARY 22, 2017

A5.0

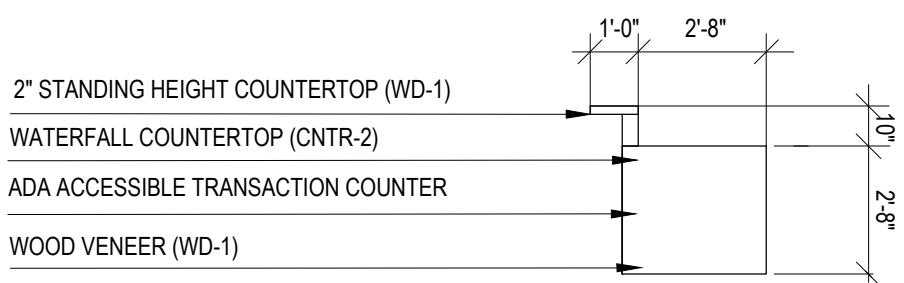

1 RECEPTIONIST STATION ELEVATION
SCALE: 1/4"=1'-0"

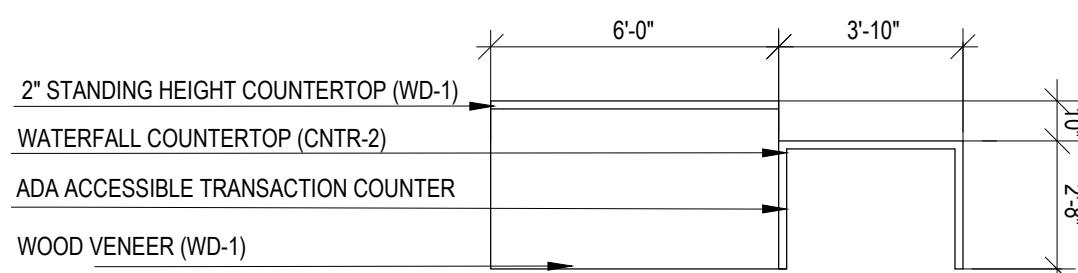

2 RECEPTIONIST STATION ELEVATION
SCALE: 1/4"=1'-0"


RECEPTIONIST STATION
ELEVATIONS

GIGIS
PLAYHOUSE

DRAWN BY:
GRACE DIETZ
COURSE: ADHM 253
DATE: FEBRUARY 22, 2017


NOTES:

-STANDARD GYPSUM BOARD
FINISH FOR SOFFIT CEILING
UNLESS OTHERWISE NOTED

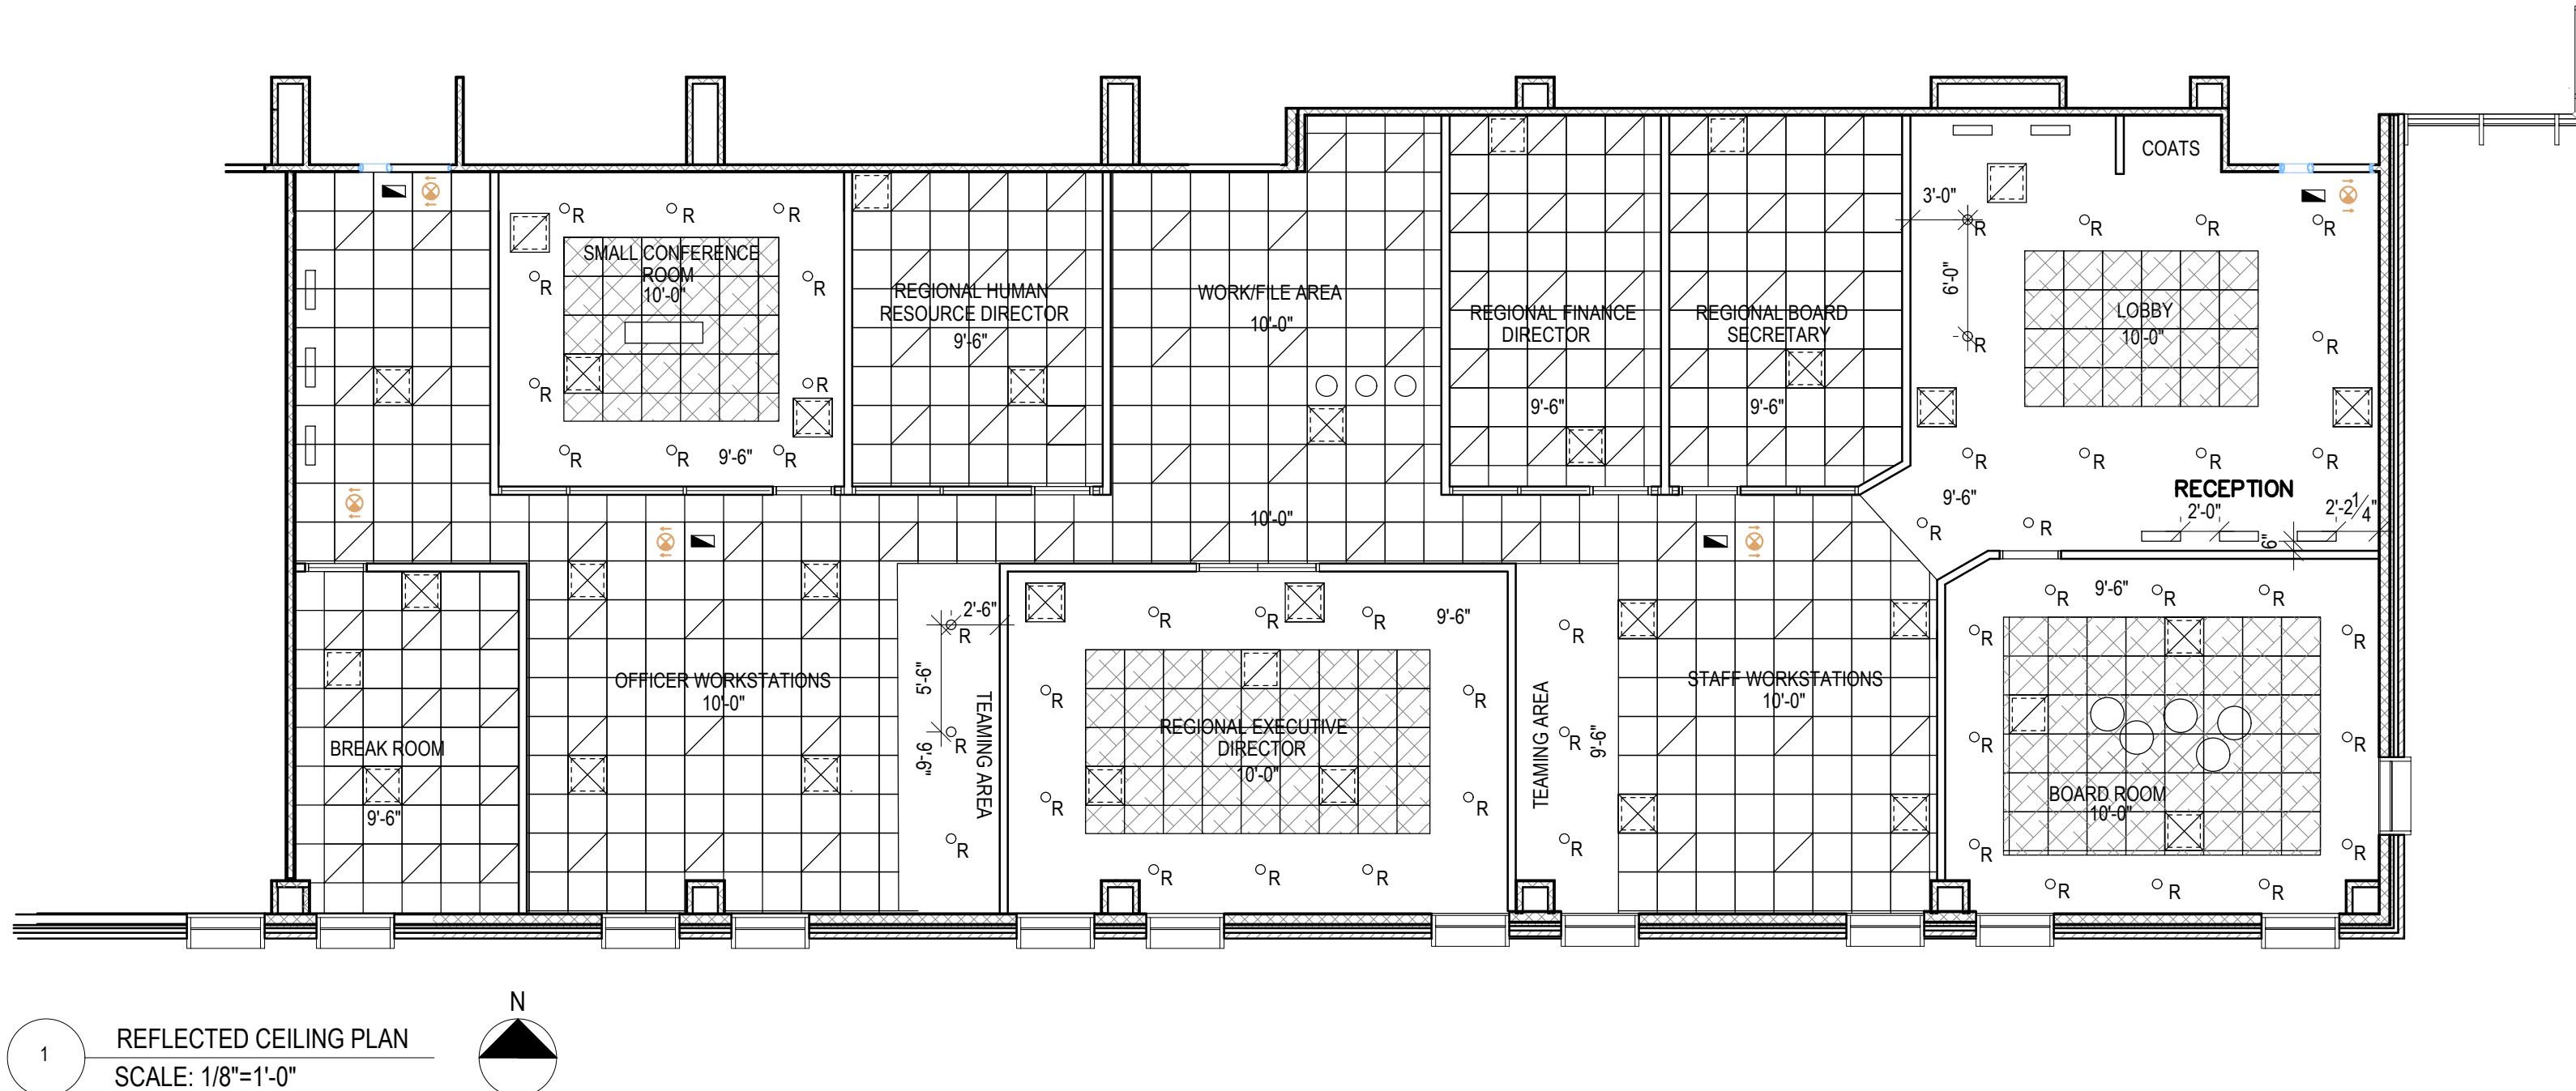

1

 REFLECTED CEILING PLAN
SCALE: 1/8"=1'-0"




LIGHTING, CEILING FINISH, AND CEILING EQUIPMENT LEGEND	
	EMERGENCY LIGHT
	EXIT LIGHT
	2'-0" x 2'-0" SUPPLY AIR DIFFUSER
	2'-0" x 2'-0" RETURN AIR GRILLE
	0'-6" RECESSED CAN LIGHT
	2'-0" x 2'-0" SURFACE LIGHT
	13 3/4" PENDANT LIGHTS
	TRACK LIGHT
	ACOUSTICAL CEILING TILE (24" X 24")
	TRANSLUCENT ACOUSTICAL CEILING TILE (24" X 24")
	20.5" PENDANT LIGHTS (X5)
	48" PENDANT LIGHT

REFLECTED CEILING PLAN

GIGIS
PLAYHOUSE

DRAWN BY:
GRACE DIETZ
COURSE: ADHM 253
DATE: FEBRUARY 22, 2017

A6.3

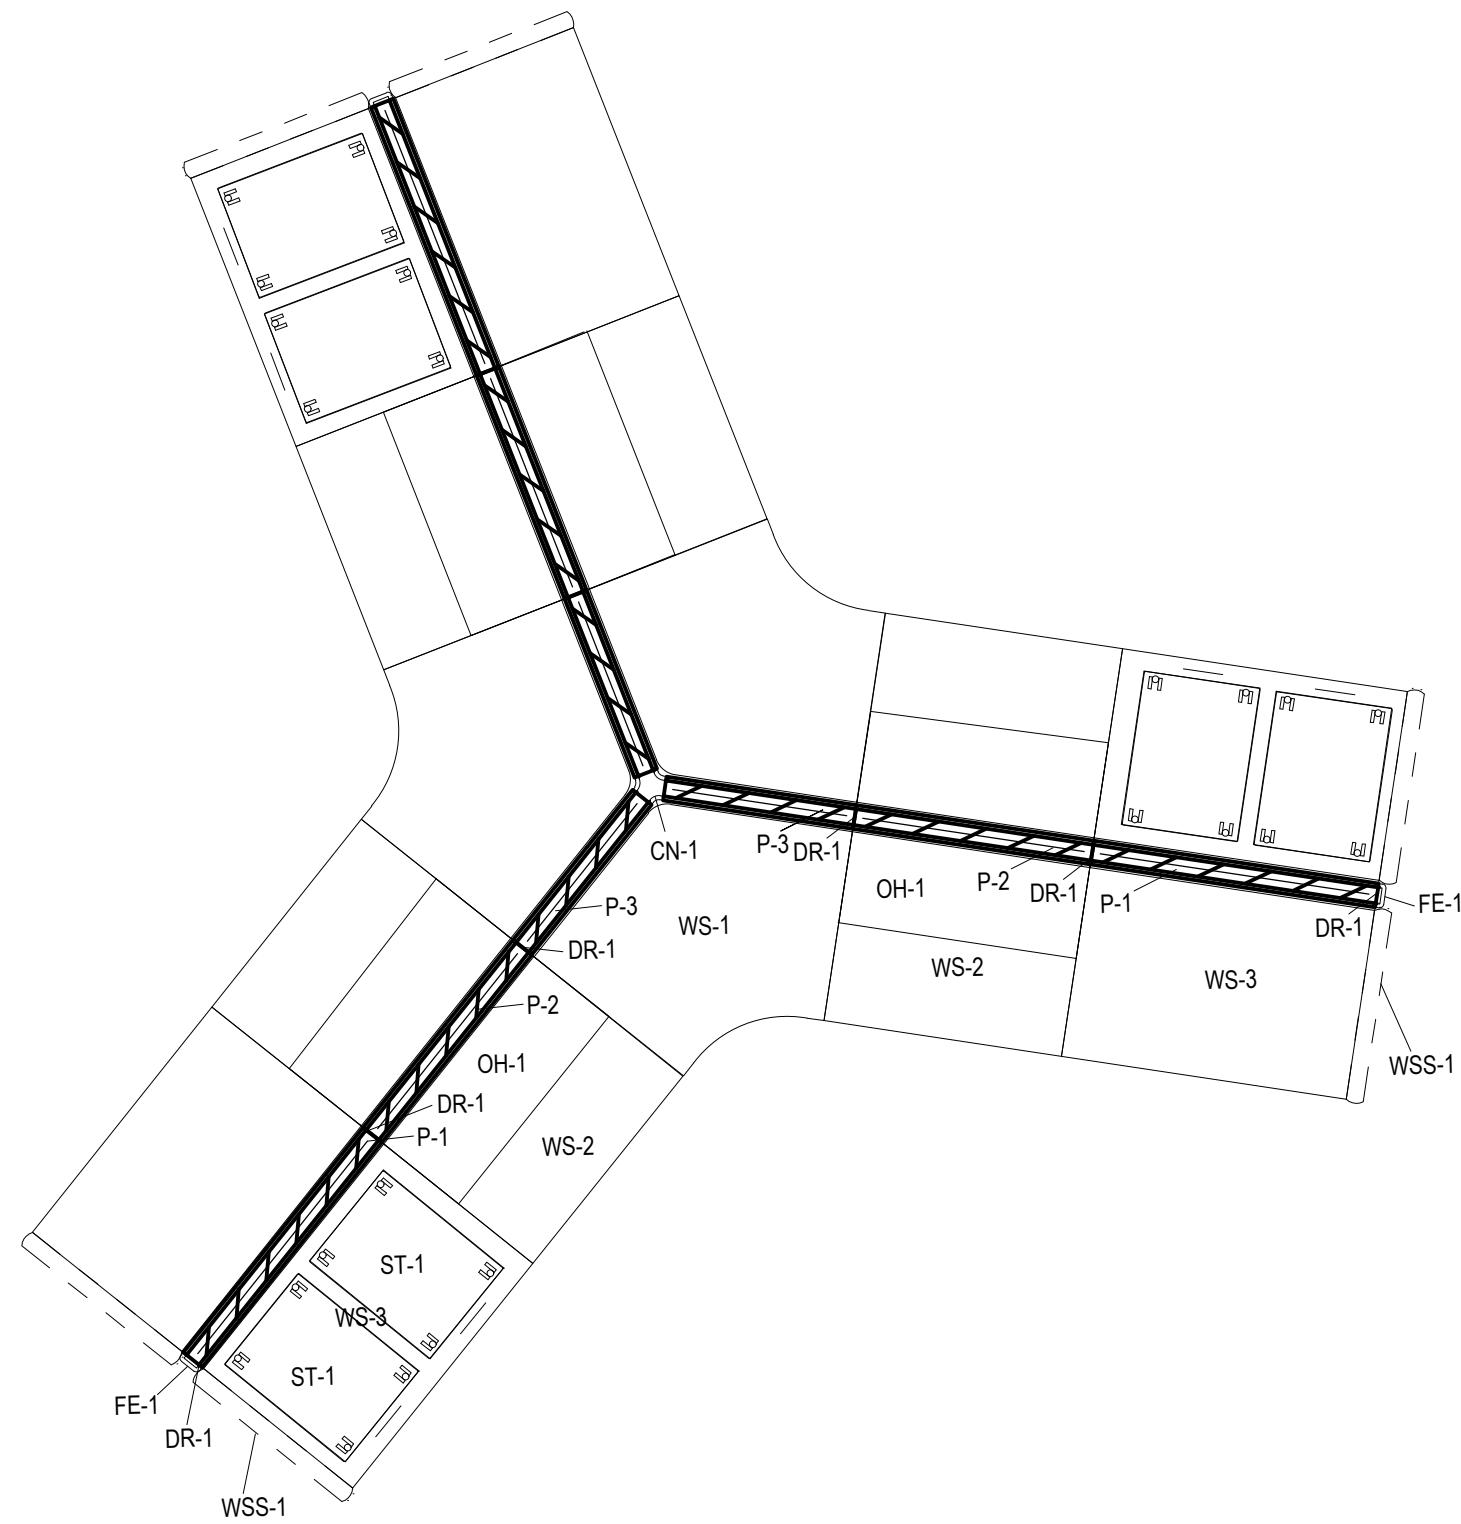

1

OFFICER WORKSTATION LARGE SCALE PLAN
SCALE: 1/2"=1'-0"

OFFICER WORKSTATION
LARGE SCALE PLAN

GIGIS
PLAYHOUSE


DRAWN BY:
GRACE DIETZ
COURSE: ADHM 253
DATE: FEBRUARY 22, 2017

A10.3

NOTES:
 -DUPLEX RECEPTACLES
 MOUNTED AT 15" AFF UN-
 LESS OTHERWISE NOTED

-GFCI RECEPTACLES
 MOUNTED AT 42" AFF UN-
 LESS OTHERWISE NOTED

-CUSTOM POWER
 ACCOMODATIONS FOR
 INTERACTIVE WALL
 INSTALLATION

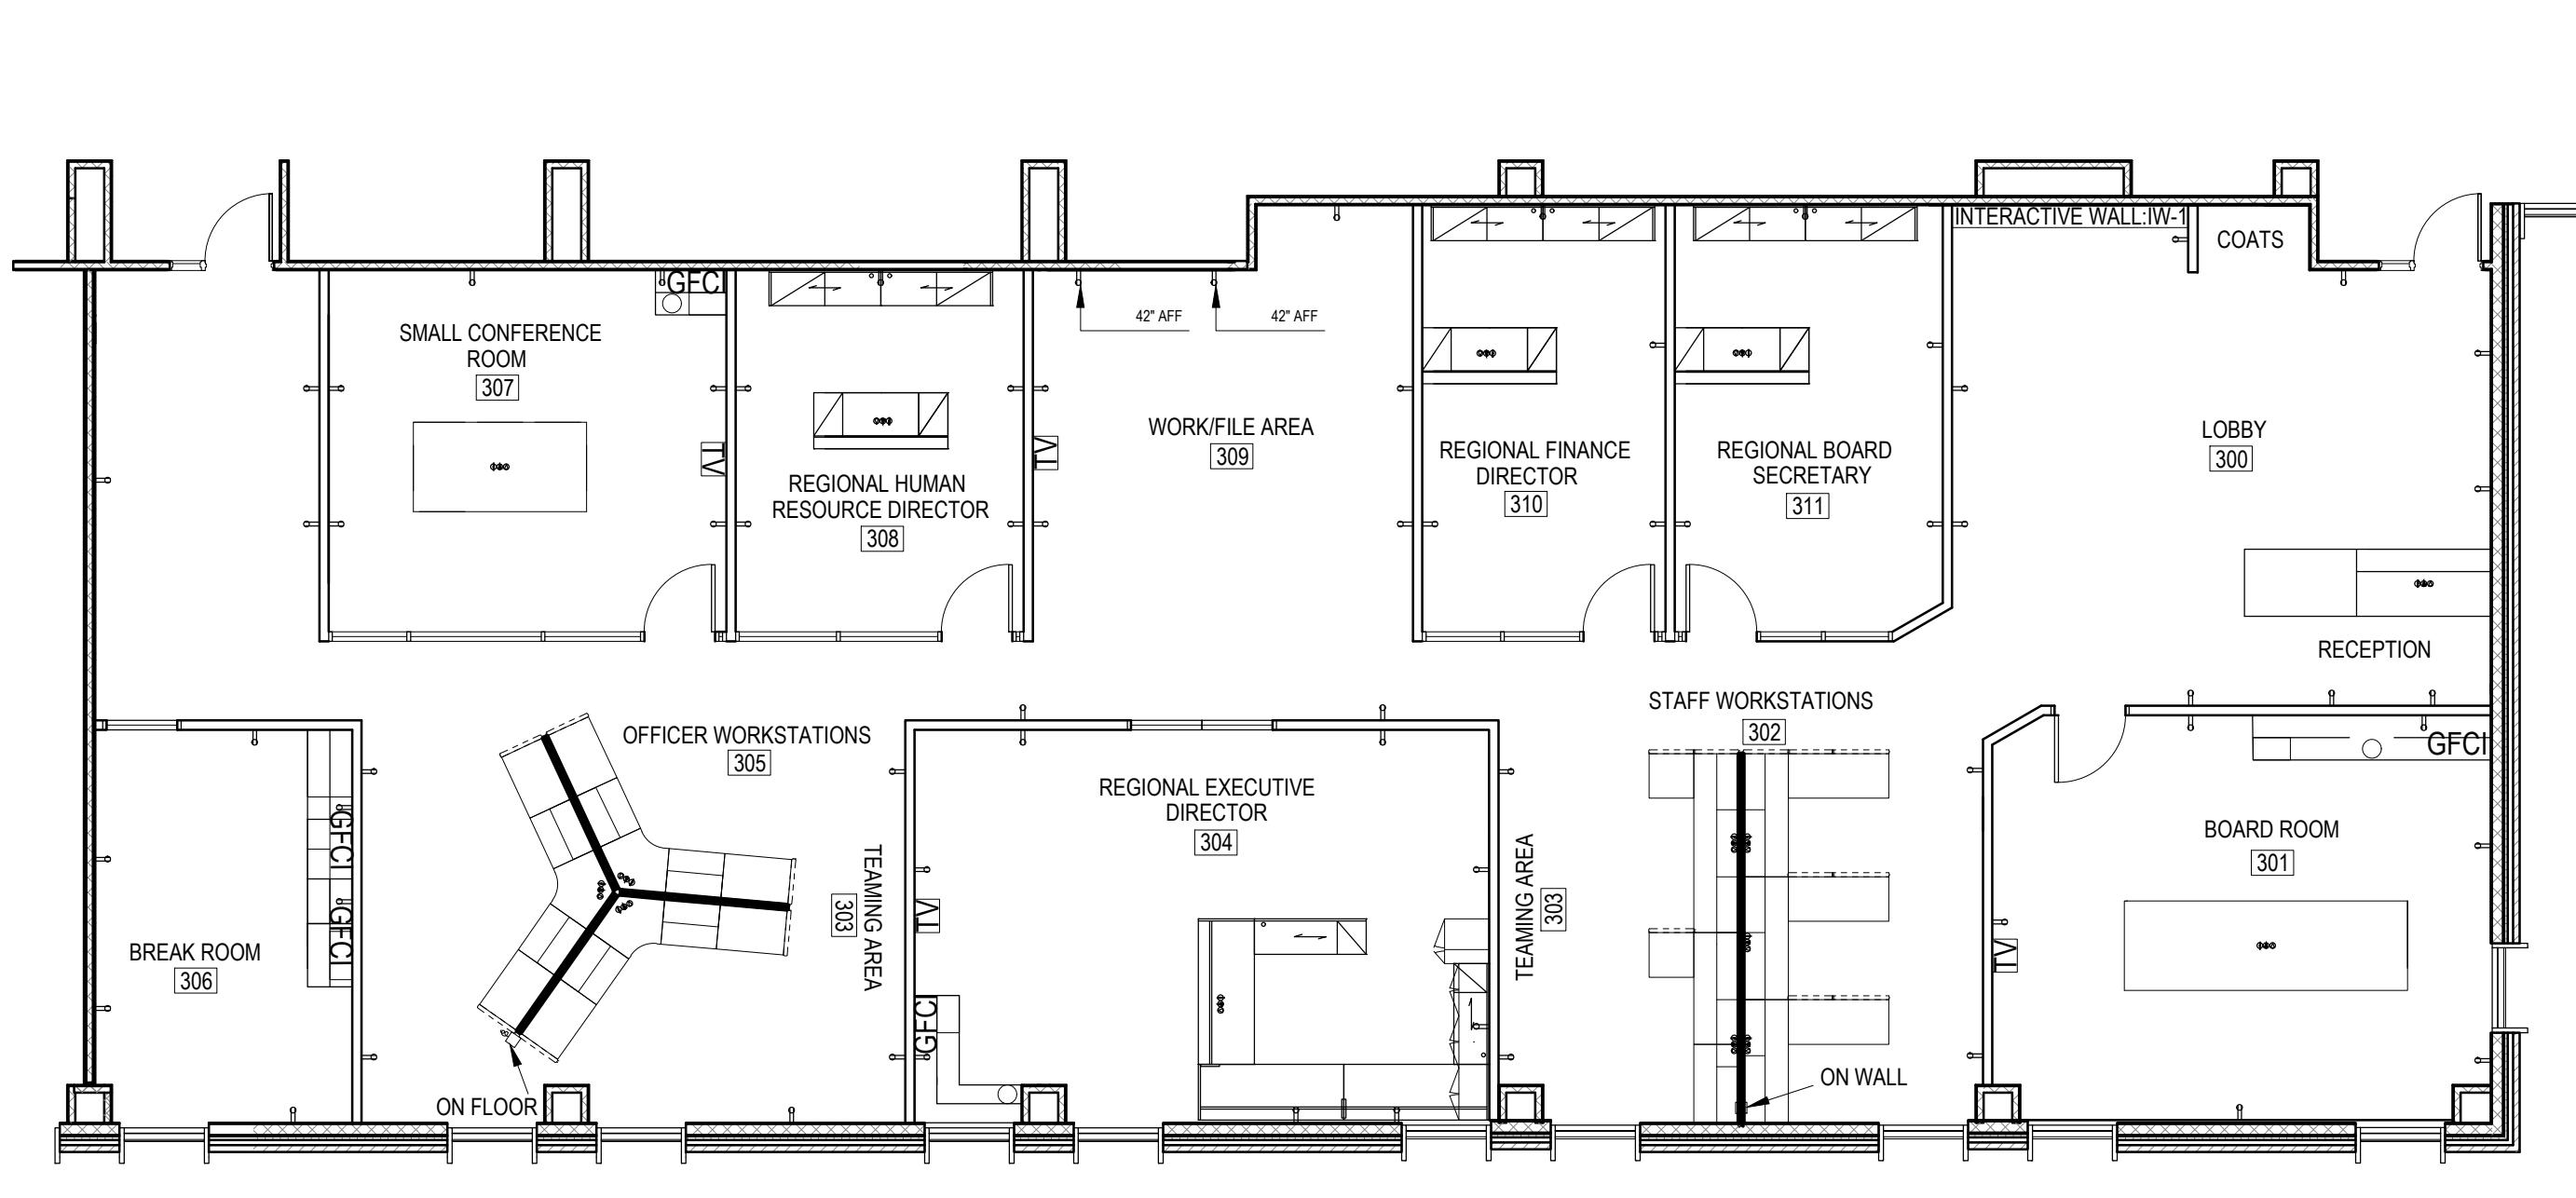

POWER AND COMMUNICATION LEGEND	
	120v DOUBLE DUPLEX RECEPTACLE
	POWER WHIP
	CABLE TV OUTLET
	DUPLEX RECEPTACLE WITH GROUND FAULT CIRCUIT INTERRUPTER
	DUPLEX FLOOR RECEPTACLE
	FLOOR TELEPHONE OUTLET
	FLOOR DATA OUTLET

1 POWER AND COMMUNICATION PLAN
 SCALE: 1/8"=1'-0"



POWER AND
 COMMUNICATION PLAN

GIGIS
 PLAYHOUSE

DRAWN BY:
 GRACE DIETZ
 COURSE: ADHM 253
 DATE: FEBRUARY 22, 2017

E2.3